

SIGN SCHEDULE

- igap A ground sign replacement face | one (1) req
- B WALL SIGN | ONE (1) REQ

GENERAL NOTES

- INSTALLER SHALL VERIFY WALL CONDITIONS IN THE FIELD
- TYPE, SIZE & QUANTITY OF FASTENERS TO BE DETERMINED
- ALL BOLT HOLES TO BE DRILLED OR PUNCHED
- ISOLATE ALL ALUMINUM FROM STEEL.

NEW & REMODEL CONSTRUCTION

ADEQUATE REHIND THE WALL BACKING AND ACCESS IS REQUIRED FOR THE INSTALLATION OF NEW SIGNAGE. CUSTOMER TO FORWARD APPROVED SIGNAGE DRAWINGS TO THE ON SITE CONTACT TO INSURE THAT THE REQUIRED PROVISIONS ARE MADE DURING CONSTRUCTION, PRIOR TO THE SIGN INSTALLATION.

NSTALLER REQUIREMENTS FOR EIFS WALLS

IT IS THE RESPONSIBILITY OF THE INSTALLATION CONTRACTOR TO PROVIDE ANY WALL SPACERS REQUIRED TO KEEP FIES WALL MATERIAL FROM BEING COMPACTED DURING INSTALLATION OF ANY MOUNTING BOLTS REQUIRED FOR SIGNAGE

INSTALLER REQUIREMENTS

ALL INSTALLATION (MOUNTING) HARDWARE AND SECONDARY WIRING COMPONENTS, CONDUIT & CONNECTORS, ETC ARE TO BE PROVIDED BY THE INSTALLATION CONTRACTOR

ALL WALL PENETRATIONS TO BE SEALED WITH SILICONE TO HELP PREVENT MOISTURE PENETRATION @ EXTERIOR LOCATIONS.

ANY DEVIATION FROM FEDERAL HEATH REQUIREMENTS MAY RESULT IN DAMAGE TO OR IMPROPER OPERATION OF SIGNAGE CAUSING DELAYS AND ADDITIONAL COSTS

CUSTOMER TO PROVIDE DEDICATED BRANCH CIRCUITS FOR **SIGNS ONLY PER NEC CODE 600.5**

ALL BRANCH CIRCUITS FOR SIGNS MUST BE TOTALLY DEDICATED
TO SIGNS (INCLUDING DEDICATED
GROUND & NEUTRAL, PER CIRCUIT)
AND SHALL NOT BE SHARED /C and OTHER EQUIPMENT) PROPERLY SIZED GROUND WIRE THAT CAN BE TRACED BACK TO THE BREAKER PANEL IS REQUIRED.

NUMBER AND SIZE OF CIRCUITS FOR EACH SIGN MUST MEET FEDERAL HEATH SIGN REQUIREMENTS.

LL ELECTRICAL SIGNS SHALL CONFORM TO HE REQUIREMENTS OF ARTICLE 600 OF THE N.E.C. AND U.L. 48 ALONG WITH OTHER APPLICABLE STATE & LOCAL CODE REQUIREMENTS. THIS INCLUDES PROPER

120V - 20 AMP (PRIMARY ELECTRICAL CUSTOMER'S CERTIFIED ELECTRICIAN. NUMBER AND SIZE OF CIRCUITS FOR EACH IGN TO MEET FEDERAL HEATH SIGN COMPAI

WARRANTY NOTICE

CERTAIN ELECTRICAL COMPONENTS OF SIGNS WILL FAIL PREMATURELY IF NOT SHUT OFF FOR A PERIOD OF TIME, ONCE EACH DAY. FOR BEST PERFORMANCE WE RECOMMEND THAT SIGNS BE CONNECTED TO AN AUTOMATIC CONTROLLING DEVICE SUCH AS AN EMERGENCY MANAGEMENT SYSTEM, TIME CLOCK OR PHOTO CELL TO CONTROL THE DAILY SHUT-OFF PERIOD. FAILURE TO FOLLOW THESE RECOMMENDATIONS CAN CAUSE DAMAGE TO ELECTRICAL COMPONENTS OF THE SIGN AND VOID THE WARRANTY. SOME DIMMING DEVICES WILL ADVERSELY AFFECT THE ELECTRICAL COMPONENTS OF THE SIGN AND VOID THE WARRANTY. SOME DIMMING DEVICES WILL ADVERSELY AFFECT THE ELECTRICAL COMPONENTS OF THE SIGN IT IS ATTACHED TO, CAUSING FAILURE. ANY DIMMING OF THE SIGN WITHOUT CONSULTATION WITH FEDERAL HEATH SIGN CO. WILL VOID THE WARRANTY.



AERIAL SITE PLAN | NTS

VISUAL COMMUNICATIONS

www.FederalHeath.com

PO BOX 153, Clinton, TN 37717

Manufacturing Facilities:

Delaware, OH - Euless, TX - Jacksonville, TX Racine, WI - Rochester Hills, MI Office Locations:

Revisions

Atlanta, GA - Brandon,FL - Indianapolis, IN Tunica, MS - Daytona Beach, FL - Delaware, OH Fuless, TX - Grafton, WI- Houston, TX Idaho Falls, ID - Louisville, KY - Ocean Ranch, CA Racine, WI - Rochester Hills, MI - San Antonio, TX Tampa, FL - Willowbrook, IL - Orlando, FL

Building Quality Signage Since 1901 Landlord Approval/Date:

R1 5.18.23 R2 BW 6.12.23 Delete opt 1 & B1. olors Depicted In This Rendering May Not Match Actual Finished Materials. Refer To Product Samples For Exact Color Matc Client Approval/Date

JOHN BROWN Account Rep: KRISTI FRANKLIN Project Manage

CHRIS H CANTRELL

Underwriters Laboratories Inc.

Underwriters Laboratories Inc.

DELECTRICAL TO USE U.L. LISTED COMPONENTS AND SHALL MEET ALL N.E.C. STANDARDS ALL ELECTRICAL SIGNS ARE TO COMPLY WITH U.L. 48 AND ARTICLE 600 OF THE N.E.C. STANDARDS, INCLUDING THE PROPER GROUNDING AND BONDING OF ALL SIGNS. Project / Location:



STORE #0401 22578 I-30 BRYANT, AR 72022

23-79278-10 Job Number 05.17.23 Sheet Number Design Number:

This original drawing s provided as part of a planned project and is not to be exhibited, copied or reproduced without the written permission of Federal Heath Sign 23-79278-10 R3 Company, LLC G. . . authorized agent. ©FHSC Company, LLC or its





EXISTING | SIDE B | NTS





A PROPOSED | SIDE A | NTS





www.FederalHeath.com

PO BOX 153, Clinton, TN 37717

Delaware, OH - Euless, TX - Jacksonville, TX Racine, WI - Rochester Hills, MI **Office Locations**:

Atlanta, GA - Brandon,FL - Indianapolis, IN Tunica, MS - Daytona Beach, FL - Delaware, OH Euless, TX - Grafton, WI- Houston, TX Idaho Falls, ID - Louisville, KY - Ocean Ranch, CA Racine, WI - Rochester Hills, MI - San Antonio, TX Tampa, FL - Willowbrook, IL - Orlando, FL

Building Quality Signage Since 1901 Landlord Approval/Date

R1 5.18.23 R2 BW 6.12.23 Delete opt 1 & B1. olors Depicted In This Rendering May Not Match Actual Finished Materials. Refer To Product Samples For Exact Color Matc

JOHN BROWN Account Rep: KRISTI FRANKLIN CHRIS H CANTRELL Underwriters
Laboratories Inc.

ALL ELECTRICAL SIGNS ARE TO COMPLY WITH U.L. 48 AND ARTICLE 600 OF THE N.E.C. STANDARDS. INCLUDING THE PROPER GROUNDING AND BONDING OF ALL SIGNS.

Project / Location:



STORE #0401 22578 I-30 BRYANT, AR 72022

23-79278-10 05.17.23 Design Number:

This original drawing s provided as part of a planned project and is not to be exhibited, copied or reproduced permission of Federal Heath Sign 23-79278-10 R3 Company, LEC 3. authorized agent. ©FHSC Company, LLC or its







SCALE: 1/2" = 1'-0"


TW0 (2) REQ

32.04 SQ. FT

SCOPE OF WORK:

REMOVE EXISTING SIGN FACE PANEL. EXISTING CABINET AND RETAINERS TO BE PAINTED GRAY AS NOTED

FACE TO BE BLACK ALUMINUM WITH DIGITALLY PRINTED GRAPHICS ON BOTH SIDES AS SHOWN

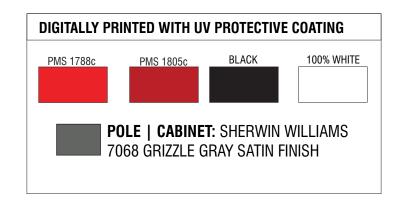



Manufacturing Facilities: Delaware, OH - Euless, TX - Jacksonville, TX Racine, WI - Rochester Hills, MI

Office Locations: Atlanta, GA - Brandon,FL - Indianapolis, IN

Tunica, MS - Daytona Beach, FL - Delaware, OH Euless, TX - Grafton, WI- Houston, TX Idaho Falls, ID - Louisville, KY - Ocean Ranch, CA Racine, WI - Rochester Hills, MI - San Antonio, TX Tampa, FL - Willowbrook, IL - Orlando, FL

Building Quality Signage Since 1901 Landlord Approval/Date

Revisions R1 5.18.23 R2 BW 6.12.23 Delete opt 1 & B1. olors Depicted In This Rendering May Not Match Actual Finished Materials. Refer To Product Samples For Exact Color Mat

JOHN BROWN Account Rep: KRISTI FRANKLIN Project Manager

CHRIS H CANTRELL Underwriters Laboratories Inc.

ALL ELECTRICAL SIGNS ARE TO COMPLY WITH U.L. 48 AND ARTICLE 600 OF THE N.E.C. STANDARDS, INCLUDING THE PROPER GROUNDING AND BONDING OF ALL SIGNS. BRYANT, AR 72022

Project / Location: CRASH CHAMPIONS STORE #0401 22578 I-30

23-79278-10 Job Number: 05.17.23 3 Sheet Number: Design Number:

provided as part of a planned project 23-79278-10 R3 Company, LLC 3. authorized agent. ©FHSC

LEAVE ENTERPRISE SIGN- DO NOT REMOVE



EXISTING | SCALE: 3/32" = 1'-0"

SCOPE OF WORK: REMOVE EXISTING LOGO WALL SIGN (SERVICE KING)- CLEAN WALL, FILL HOLED WITH MATCHING SILICONE AND PAINT IMMEDIATE FOOTPRINT. INSTALL NEW SIGN. CHANNEL LETTERSET (COLLISION REPAIR CENTER) - REMOVE CHANNEL LETTERSET AND RACEWAY. CLEAN WALL, FILL HOLES WITH MATCHING SILICONE AND PAINT IMMEDIATE FOOTPRINT.



B PROPOSED | SCALE: 3/32" = 1'-0"



PO BOX 153, Clinton, TN 37717

Manufacturing Facilities:
Delaware, OH - Euless, TX - Jacksonville, TX
Racine, WI - Rochester Hills, MI
Office Locations:
Atlanta, GA - Brandon,FL - Indianapolis, IN

Atlanta, GA - Brandon, FL - Indianapolis, IN Tunica, MS - Daytona Beach, FL - Delaware, OH Euless, TX - Grafton, WI- Houston, TX Idaho Falls, ID - Louisville, KY - Ocean Ranch, CA Racine, WI - Rochester Hills, MI - San Antonio, TX Tampa, FL - Willowbrook, IL - Orlando, FL

iampa, FL - Willowbrook, IL - Oriando, FL				
Building	Quality	Signage	Since	1901

R1 5.18.23

R2 BW 6.12.23 Delete opt 1 & B1.

R3 CHC Update Sign B to CCWS-L-26

Colors Depicted In This Rendering May Not Match Actual Finished Materials. Refer To Product Samples For Exact Color Match.

Client Approval/Date:

Landlord Approval/Date:

Account Rep: JOHN BROWN
Project Manager: KRISTI FRANKLIN
Drawn By: CHRIS H CANTRELL
Underwriters Laboratories Inc. Laboratories Inc. Underwriters Laboratories Inc. Labora
ALL ELECTRICAL SIGNS ARE TO COMPLY WITH U.L. 48 AND ARTICLE 600 OF THE N.E.C. STANDARDS, INCLUDING THE PROPER GROUNDING AND BONDING OF ALL SIGNS.

CRASH
CHAMPIONS
COLLISION REPAIR TEAM

STORE #0401
22578 I-30
BRYANT, AR 72022


 Job Number:
 23-79278-10

 Date:
 05.17.23


 Sheet Number:
 4 Of 8

 Design Number:
 23-79278-10 R3

This original drawing is provided as part of a planned project and is not to be exhibited, copied or reproduced without the written permission of Federal Heath Sign Company, LLC or its authorized agent. ©FHSC

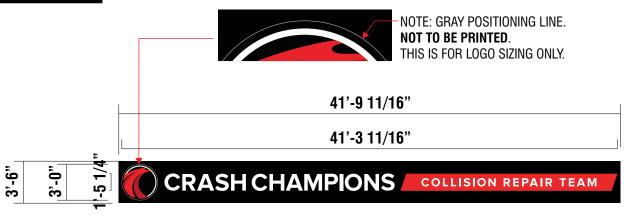

 NOTE: BACKGROUND PANEL WILL BE SEAMED AT 12'-0" INCREMENTS



INTERNALLY ILLUMINATED LOGO & LETTERSET ON PANEL | ONE (1) REQ

SCALE: 1/8" = 1'-0"

SCOPE OF WORK:

CHANNEL LOGO: 5" DEEP .040 PRE-FINISHED ALUMINUM LOGO CABINET. SATIN BLACK RETURNS & TRIMCAP 3/16" WHITE ACRYLIC FACE. DIGITAL PRINT OVERLAY, BLACK PRINTED BORDER TO BE ON FACE AND RUN UNDER TRIMCAP. WHITE LEDS. INSTALL FLUSH TO BACKER.

CRASH CHAMPIONS CHANNEL LETTERS: 5" DEEP .040 PRE-FINISHED ALUMINUM CHANNEL LETTERS. SATIN BLACK RETURNS AND TRIM CAP. 3/16" WHITE ACRYLIC FACE. WHITE LEDS. INSTALL FLUSH TO BACKER.

COLLISION REPAIR TEAM TAG LINE CABINET: 5" DEEP .040 PRE-FINISHED ALUMINUM CHANNEL TAG LINE. SATIN RED RETURNS AND TRIM CAP. 3/16" WHITE ACRYLIC FACE WITH DIGITAL PRINT OVERLAY PMS 1788C. COPY WILL REVERSE OUT WHITE. INTERNAL WHITE LEDS. CABINET INSTALL FLUSH TO BACKER.

ALUMINUM BACKER: 3" DEEP ALUMINUM BACKER PANEL/WIREWAY TO BE PAINTED BLACK PC AND INSTALLS FLUSH TO WALL


FABRICATION TO BE AS NOTED TO MATCH CUSTOMER SIGN PROGRAM AND EXISTING SITES

2. ACM BACKS / LETTER LOCKED TO RETURNS

4. TRIM CAP TO BE 1" PRE-FINISHED JEWELITE CHEMICALLY BONDED TO FACES (SEAMS AT THE TOP) LOGO: BLACK TRIM CAP **CRASH: BLACK TRIM CAP CHAMPIONS: BLACK TRIM CAP COLLISION REPAIR TEAM CABINET: RED TRIM CAP**

5. WHITE LED MODULES

- 6. RIGID PASS-THRU FOR LOW VOLTAGE LED WIRING
- 7. 1/4" WEEP HOLES WITH LIGHT BAFFLES (EXTERIOR APPLICATIONS ONLY)
- 8. ETL COMPLIANT ENCLOSURE FOR LED POWER SUPPLIES +/- 18"L X 7"H. REMOTE LOCATED
- 9. DISCONNECT SWITCH
- 10. LED POWER SUPPLIES
- 11. PRIMARY ELECTRICAL
- 12. CORROSION RESISTANT FASTENERS PER CONDITIONS
- 13. ALUM. BACKGROUND PANEL/WIREWAY

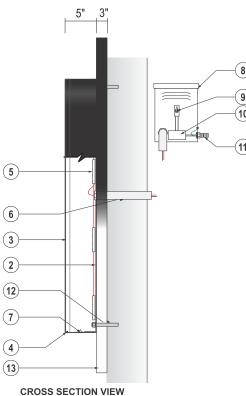

SCALE: NTS



DIGITALLY PRINTED COLORS

DP-2 PRINT TO MATCH PMS 1788C ON 3M WHITE TRANSLUCENT VINYL

PRINT TO MATCH PMS 1805C ON 3M WHITE TRANSLUCENT VINYL

PRINT TO MATCH BLACK PC ON 3M WHITE TRANSLUCENT VINYL

INSTALLER NOTE:

INSTALLER RESPONSIBLE TO CHOOSE THE APPROPRIATE FASTENERS PER CONDITIONS

ELECTRICAL REQUIREMENTS

Total: T.B.D. Amps

of 120V, 20A Circuits Req'd T.B.D.

ALL BRANCH CIRCUITS SHALL BE DEDICATED TO SIGNS (INCLUDING GROUND AND NEUTRAL) AND SHALL NOT BE SHARED WITH OTHER LOADS

REFER TO PAGE 1 FOR ADDITIONAL **ELECTRICAL AND** INSTALLATION INFORMATION & REQUIREMENTS

INSTALLATION OF THIS SIGN SHALL CONFORM TO ARTICLE 600 OF THE NEC, UL 48 AND OR OTHER APPLICABLE LOCAL CODES, INCLUDING THE PROPER GROUNDING AND BONDING OF THE SIGN

THE LOCATION OF THE DISCONNECT SWITCH, AFTER INSTALLATION SHALL COMPLY WITH ARTICLE 600.6(A) OF THE NEC



Manufacturing Facilities:

Delaware, OH - Euless, TX - Jacksonville, TX Bacine WI - Bochester Hills MI Office Locations:

Atlanta, GA - Brandon,FL - Indianapolis, IN Tunica, MS - Daytona Beach, FL - Delaware, OH Fuless, TX - Grafton, WI- Houston, TX Idaho Falls, ID - Louisville, KY - Ocean Ranch, CA Racine, WI - Rochester Hills, MI - San Antonio, TX Tampa, FL - Willowbrook, IL - Orlando, FL

Building Quality Signage Since 1901 Landlord Approval/Date

Revisions R1 5.18.23 R2 BW 6.12.23 Delete opt 1 & B1. olors Depicted In This Rendering May Not Match Actual Finished Materials. Refer To Product Samples For Exact Color Mat Client Approval/Date ALL ELECTRICAL SIGNS ARE TO COMPLY WITH U.L. 48 AND ARTICLE 600 OF THE N.E.C. STANDARDS, INCLUDING THE PROPER GROUNDING AND BONDING OF ALL SIGNS.

JOHN BROWN Account Rep: KRISTI FRANKLIN Project Manage CHRIS H CANTRELI Underwriters
Laboratories Inc.

Underwriters
Laboratories Inc.

Project / Location:



STORE #0401 22578 I-30 BRYANT, AR 72022

23-79278-10 Job Number 05.17.23 5 Sheet Number 23-79278-10 R3 Desian Number

provided as part of a olanned project ederal Heath Sign Company, LLC or its authorized agent. ©FHSC

THE FOLLOWING SIGNS ARE TYPICAL ON ALL SITES

INSTALL AGENT TO REMOVE SIGN(S), REMOVE HARDWARE AND TURN INTO THE FRONT DESK IF SIGNS ARE STILL ON SITE





Revisions



Production Board Month of Jaw Metrics That I atter 100 100 89 923 100 124 923 951 95.8 104,000 MTD 719-243-5352

ANY SANDWICH BOARDS

RATES SIGN

PRODUCTION BOARDS



PO BOX 153, Clinton, TN 37717

Manufacturing Facilities: Delaware, OH - Euless, TX - Jacksonville, TX Racine, WI - Rochester Hills, MI

Office Locations: Atlanta, GA - Brandon,FL - Indianapolis, IN Tunica, MS - Daytona Beach, FL - Delaware, OH Euless, TX - Grafton, WI- Houston, TX Idaho Falls, ID - Louisville, KY - Ocean Ranch, CA Racine, WI - Rochester Hills, MI - San Antonio, TX Tampa, FL - Willowbrook, IL - Orlando, FL

R1 5.18.23 R2 BW 6.12.23 Delete opt 1 & B1. olors Depicted In This Rendering May Not Match Actual Finished Materials. Refer To Product Samples For Exact Color Mat Building Quality Signage Since 1901 Landlord Approval/Date

JOHN BROWN Account Rep: KRISTI FRANKLIN Project Manager CHRIS H CANTRELL Underwriters Laboratories Inc. ALL ELECTRICAL SIGNS ARE TO COMPLY WITH U.L. 48 AND ARTICLE 600 OF THE N.E.C. STANDARDS, INCLUDING THE PROPER GROUNDING AND BONDING OF ALL SIGNS.

Project / Location: CRASH CHAMPIONS STORE #0401 22578 I-30


BRYANT, AR 72022


23-79278-10 Job Number: 05.17.23 Sheet Number: Design Number:

This original drawing s provided as part of a planned project copied or reproduced permission of Federal Heath Sign 23-79278-10 R3 Company, LLC 3. authorized agent. ©FHSC






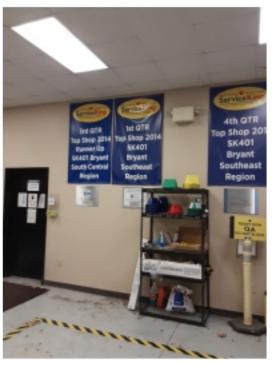


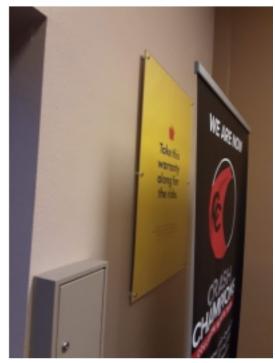



Revisions

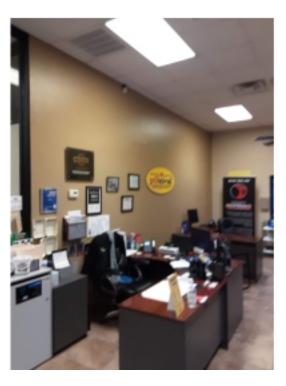

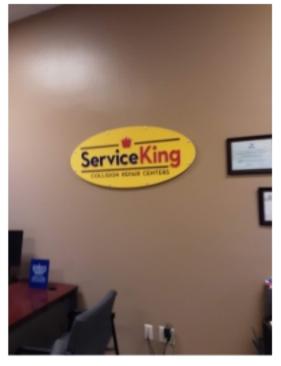



PO BOX 153, Clinton, TN 37717

Manufacturing Facilities:

Delaware, OH - Euless, TX - Jacksonville, TX Racine, WI - Rochester Hills, MI Office Locations:

Atlanta, GA - Brandon,FL - Indianapolis, IN Tunica, MS - Daytona Beach, FL - Delaware, OH Euless, TX - Grafton, WI- Houston, TX Idaho Falls, ID - Louisville, KY - Ocean Ranch, CA Racine, WI - Rochester Hills, MI - San Antonio, TX Tampa, FL - Willowbrook, IL - Orlando, FL

Building Quality Signage Since 1901 Landlord Approval/Date:

R1 5.18.23 R2 BW 6.12.23 Delete opt 1 & B1. olors Depicted In This Rendering May Not Match Actual Finished Materials. Refer To Product Samples For Exact Color Matc

JOHN BROWN Account Rep: KRISTI FRANKLIN Project Manager CHRIS H CANTRELL

Underwriters Laboratories Inc.

ALL ELECTRICAL SIGNS ARE TO COMPLY WITH U.L. 48 AND ARTICLE 600 OF THE N.E.C. STANDARDS, INCLUDING THE PROPER GROUNDING AND BONDING OF ALL SIGNS.

Project / Location:



STORE #0401 22578 I-30 BRYANT, AR 72022

23-79278-10 Job Number: 05.17.23 Design Number:

This original drawing s provided as part of a planned project and is not to be exhibited, copied or reproduced Federal Heath Sign 23-79278-10 R3 Company, LLC or its authorized agent. ©FHSC

SCOPE: REMOVAL ONLY

WALL SIGNS- PRO MODEL, CROWN LOGO OR AREA ID'S LIKE REFINISHING DEPT, BODY, SANITATION STATION, ETC. REMOVE SIGNS AND FILL HOLES WITH WATER RESISTANT SILICONE IF ON A WALL.


- -IF ON A CHAIN, REMOVE CHAINS ALONG WITH SIGN.
- -IF ON A POLE AND BOLTED DOWN REMOVE THE POLE.
- -IF IT IS A MOVABLE SIGN THE KIND WITH THE BIG BASE THAT GETS FILLED WITH WATER OR SAND, WE WILL WANT TO RECOMMEND REMOVAL OF THE ENTIRE SIGN.
- -IF SIGNS ARE IN A GRASSY AREA, CUT POLE TO GRADE AND COVER WITH DIRT.









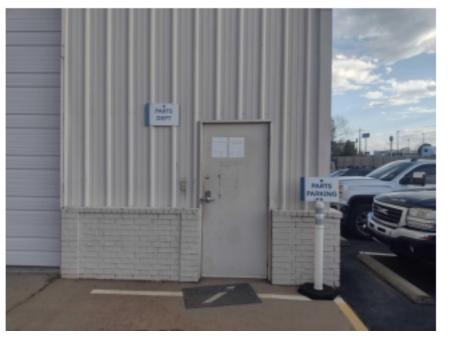



Manufacturing Facilities:
Delaware, OH - Euless, TX - Jacksonville, TX
Racine, WI - Rochester Hills, MI
Office Locations:

Revisions

Atlanta, GA - Brandon,FL - Indianapolis, IN Tunica, MS - Daytona Beach, FL - Delaware, OH Euless, TX - Grafton, WI- Houston, TX Idaho Falls, ID - Louisville, KY - Ocean Ranch, CA Racine, WI - Rochester Hills, MI - San Antonio, TX Tampa, FL - Willowbrook, IL - Orlando, FL

Building Quality Signage Since 1901 Landlord Approval/Date:

R1 5.18.23

R2 BW 6.12.23 Delete opt 1 & B1.

R3 CHC Update Sign B to CCWS-L-26

Colors Depicted In This Rendering May Not Match Actual Finished Materials. Refer To Product Samples For Exact Color Match

Client Approval/Date:

Landlord Approval/Date:

Account Rep:

Project Manager:

CHRIS H CANTRELL

Drawn By:

CHRIS H CANTRELL

UL Underwriters
Laboratories Inc.

ALL ELECTRICAL SIGNS ARE TO COMPLY WITH U.L. 48 AND ARTICLE 600 OF THE N.E.C. STANDARDS, INCLUDING THE PROPER GROUNDING AND BONDING OF ALL SIGNS.

Project / Location:



STORE #0401 22578 I-30 BRYANT, AR 72022
 Job Number:
 23-79278-10

 Date:
 05.17.23

 Sheet Number:
 8 Of 8

 Design Number:
 23-79278-10 R3

23-79278-10

05.17.23

8 of 8

23-79278-10 R3

This original drawing is provided as part of a planned project and is not to be exhibited, copied or reproduced without the written permission of Federal Heath Sign Company, LLC or its authorized agent. ©FHSC